



ISSUED FOR SITE PLAN APPROVAL 2024-11-28



DRAWING LIST

CIVIL DRAWINGS

C-01A C-02A C-03A C-04A C-05A

SITE GRADING PLAN (EARLY WORKS) SITE SERVICING PLAN (EARLY WORKS) EROSION AND SEDIMENT CONTROL PLAN (EARLY WORKS) GENERAL NOTES (EARLY WORKS) STANDARD DRAWINGS AND DETAILS (EARLY WORKS)

LANDSCAPE DRAWINGS

L000. L010. L011 L101. L110. EARLY WORKS - TREE PRESERVATION PLAN EARLY WORKS - LANDSCAPE DEMOLITION PLAN EARLY WORKS - LANDSCAPE DEMOLITION PLAN EARLY WORKS - LANDSCAPE SITE PLAN EARLY WORKS - LANDSCAPE SITE PLAN

Architect **Diamond Schmitt Architects** 384 Adelaide Street West, Suite 100 Toronto, ON M5V 1R7 T: (416)-862-8800

Structural Consultant Read Jones Christoffersen Ltd. 100 University Ave Toronto, ON M5H 4H2 T: (416)-977-5335

Electrical Consultant **EXP** 220 Commerce Valley Drive West, Suite 110 Markham, ON M3T 0A8 T: (905)-695-3217

Civil Consultant **LEA Consulting Ltd.** 625 Cochrane Drive, 5th Floor

Markham, ON L3R 9R9 T: (905)-470-0015



ARCHITECTURAL DRAWINGS

EW002 SITE SURVEY EW010 EARLY WORKS - CONTEXT PLAN EW011A EARLY WORKS - DEMOLITION SITE PLAN EW011B EARLY WORKS - DEMOLITION ENLARGED SITE PLAN EW012A EW012B EARLY WORKS - SITE PLAN EARLY WORKS - ENLARGED SITE PLAN EW013 EARLY WORKS - PHASING DIAGRAMS EW015 EARLY WORKS - EXISTING HOSPITAL

M001E M101E M102E M103E

MECHANICAL DRAWINGS

MECHANICAL SYMBOLS, LEGENDS, DRAWING LIST & SITE PLAN - EARLY WORKS FUEL TANK RELOCATION AIR HANDLING UNIT RELOCATION

MECHANICAL DETAILS

STRUCTURAL DRAWINGS

S100. EARLY WORKS GENERAL NOTES S101. S200. EARLY WORKS GENERAL NOTES EARLY WORKS - SITE PLAN

Mechanical Consultant EXP

220 Commerce Valley Drive West, Suite 110 Markham, ON M3T 0A8 T: (905)-695-3217


Landscape Architect


GSP Group 72 Victoria Street South, Suite 201 Kitchener, ON N2G 4Y9 T: (519)-569-8883

ELECTRICAL DRAWINGS

E101E ELECTRICAL SITE PLAN - EARLY WORKS E201E ELECTRICAL DETAILS & SINGLE LINE DIAGRAM - EARLY WORKS



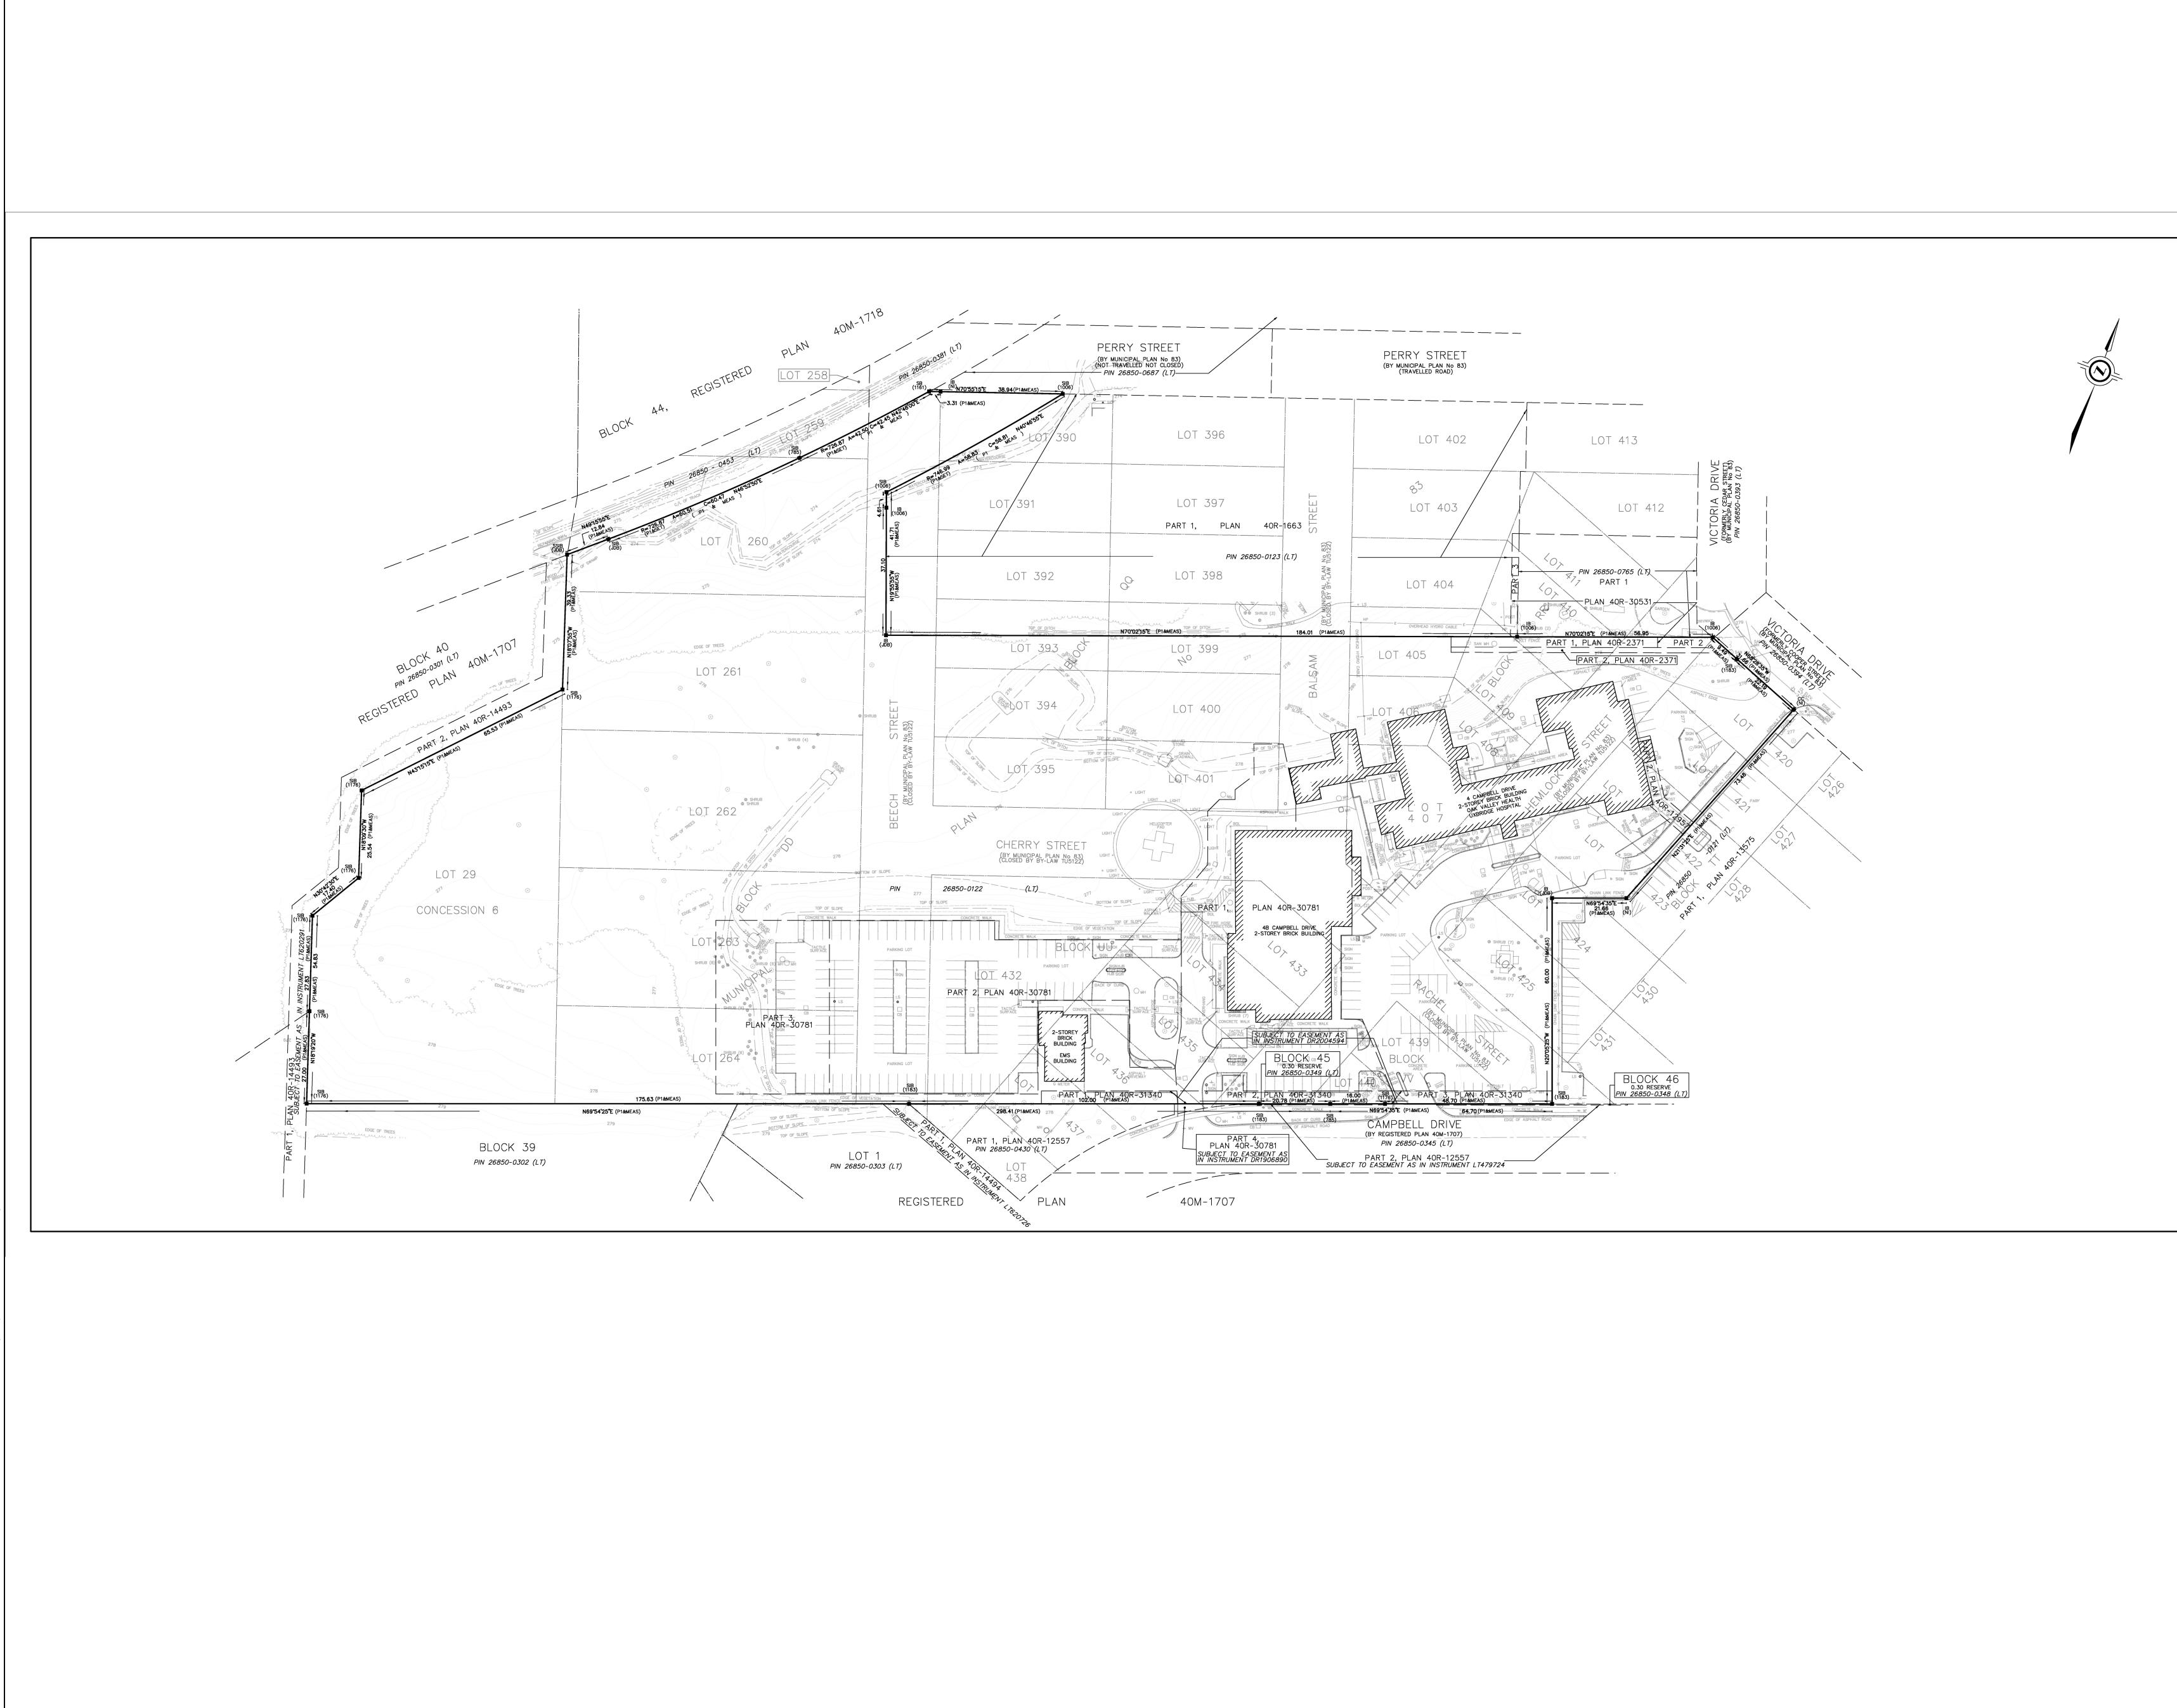

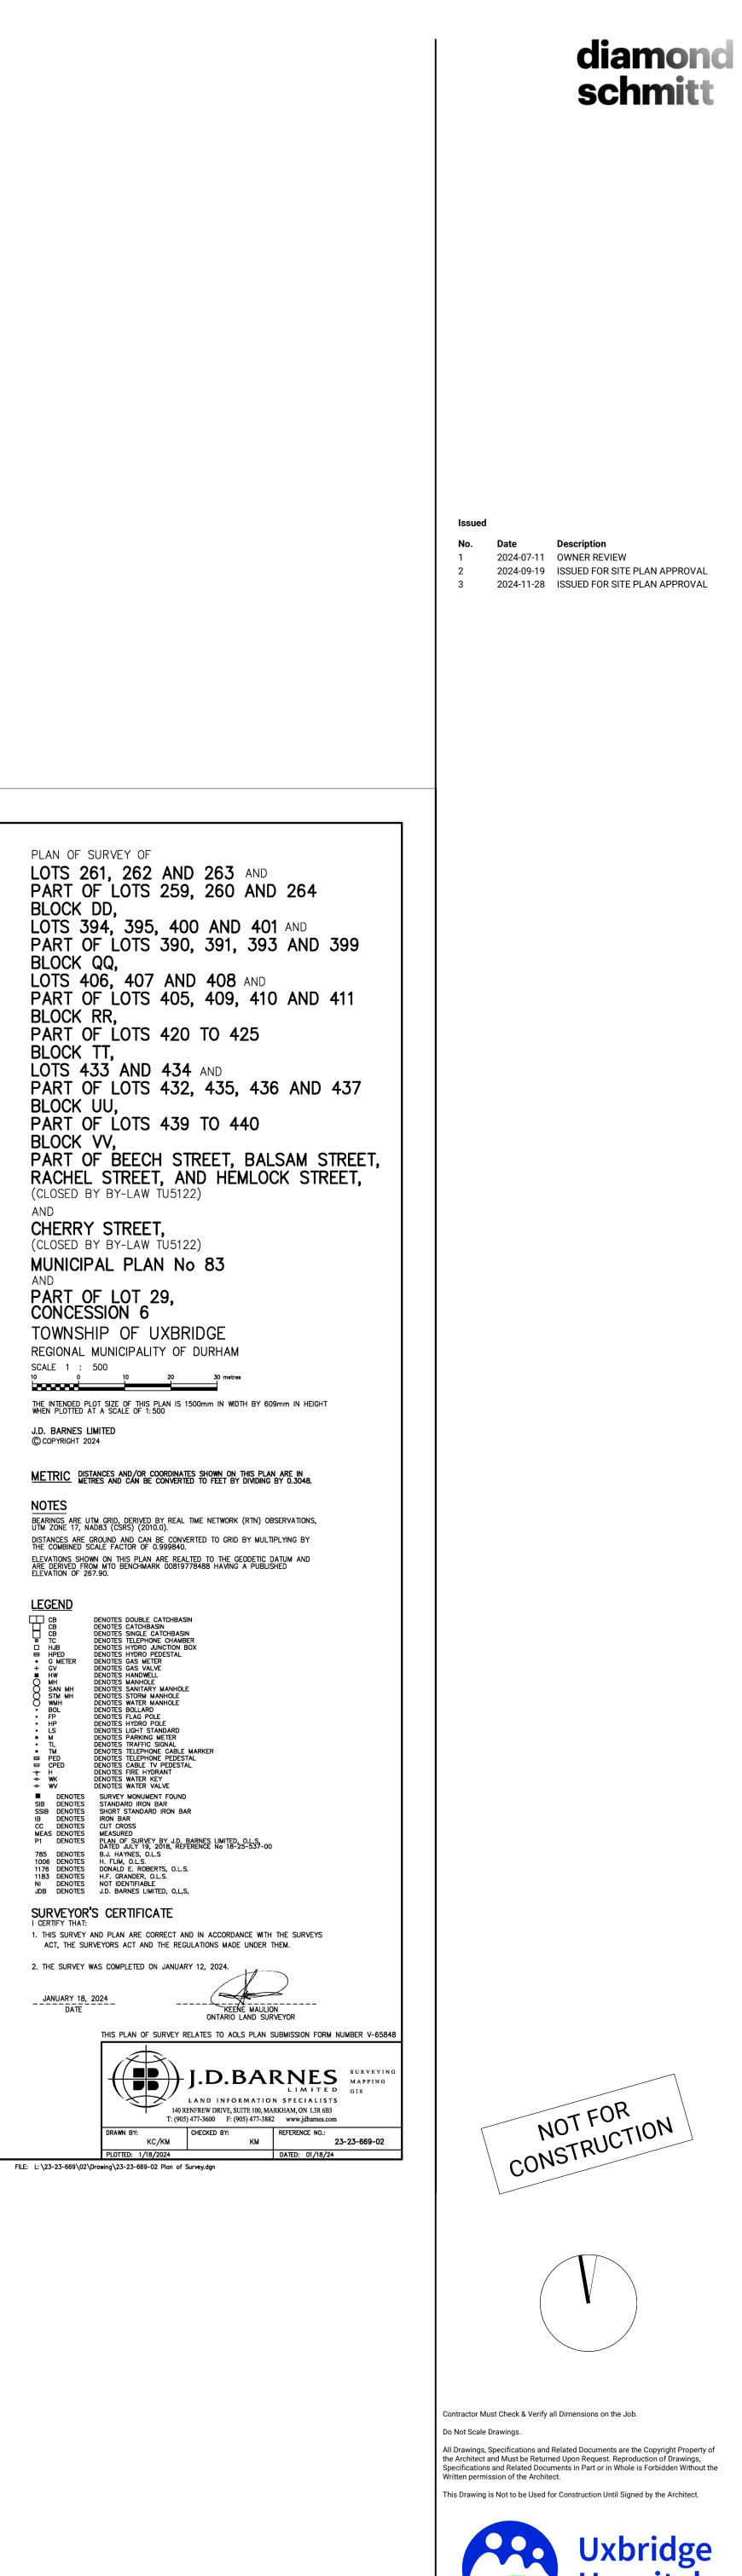

PLAN OF SURVEY OF

AND

J.D. BARNES LIMITED © COPYRIGHT 2024

NOTES

LEGEND

JANUARY 18, 2024


DRAWN BY:



OAK VALLEY HEALTH -UXBRIDGE HOSPITAL 4 CAMPBELL DRIVE, UXBRIDGE, ON PROJECT NO.: 231022

SITE SURVEY

EW002

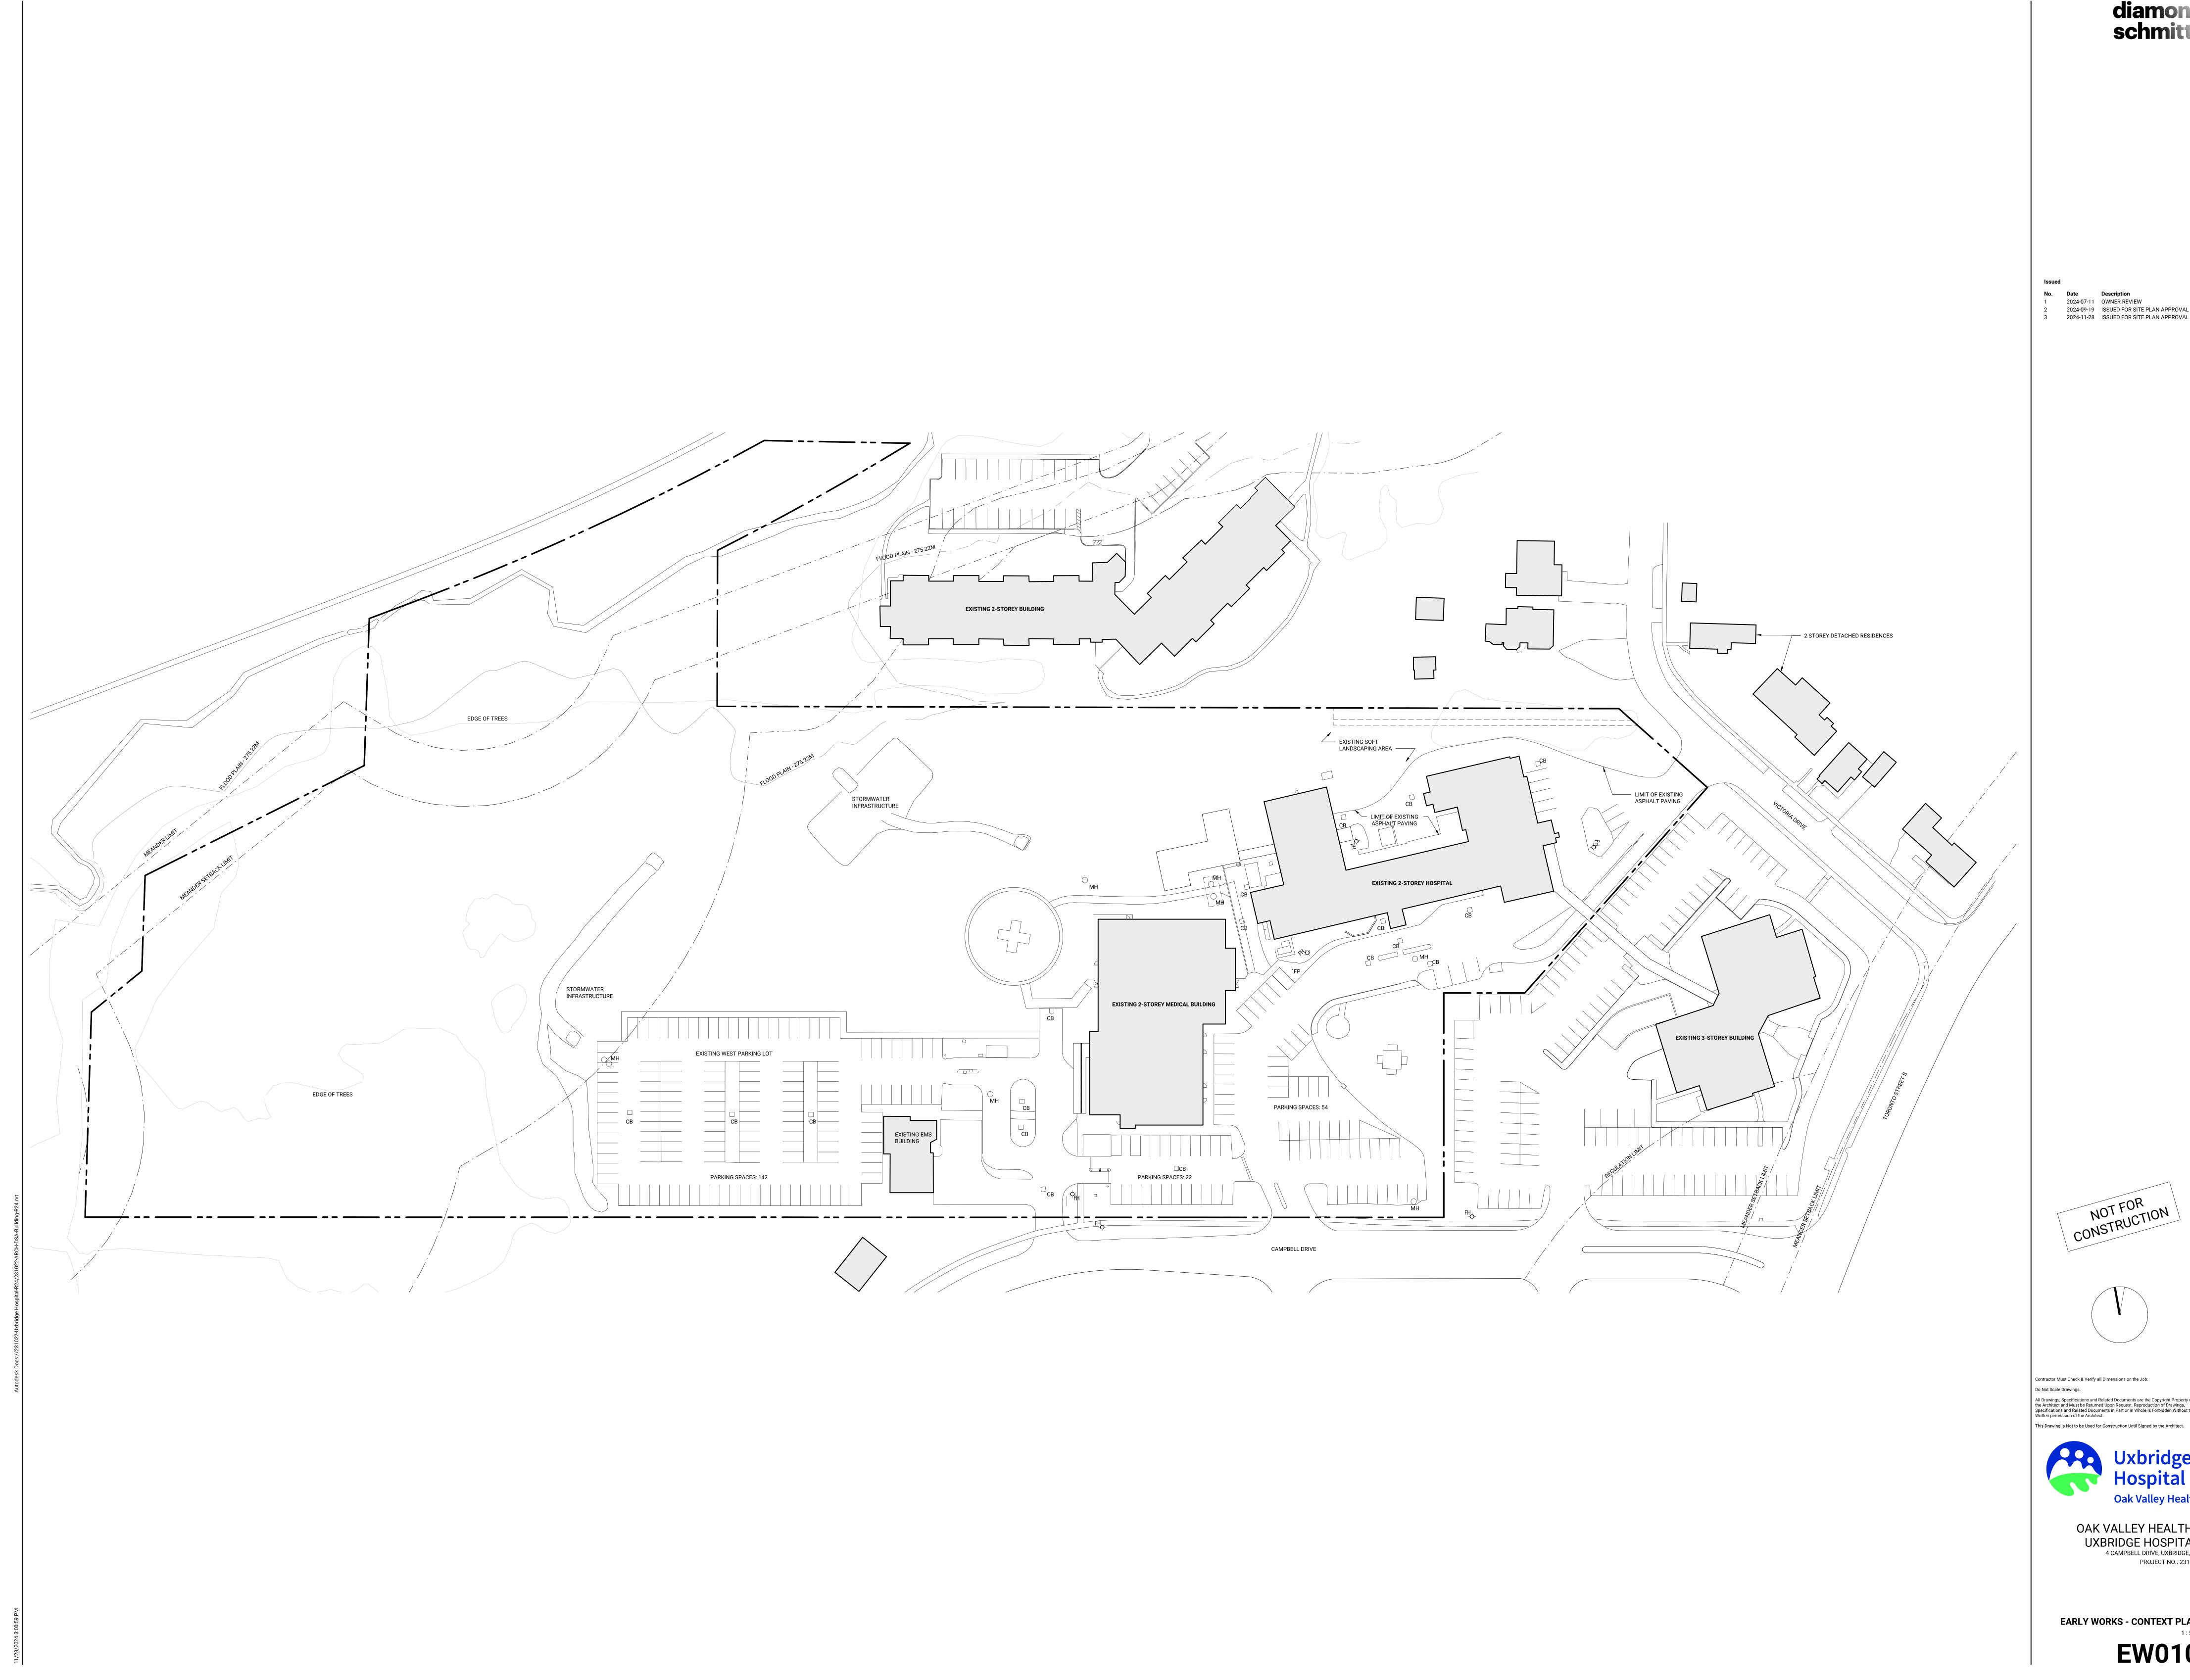



EARLY WORKS - CONTEXT PLAN

EW010

PROJECT NO.: 231022

OAK VALLEY HEALTH -UXBRIDGE HOSPITAL 4 CAMPBELL DRIVE, UXBRIDGE, ON




Contractor Must Check & Verify all Dimensions on the Job. Do Not Scale Drawings. All Drawings, Specifications and Related Documents are the Copyright Property of the Architect and Must be Returned Upon Request. Reproduction of Drawings, Specifications and Related Documents in Part or in Whole is Forbidden Without the Written permission of the Architect.

NOT FOR CONSTRUCTION

Issued No.DateDescription12024-07-11OWNER REVIEW22024-09-19ISSUED FOR SITE PLAN APPROVAL32024-11-28ISSUED FOR SITE PLAN APPROVAL

diamond schmitt

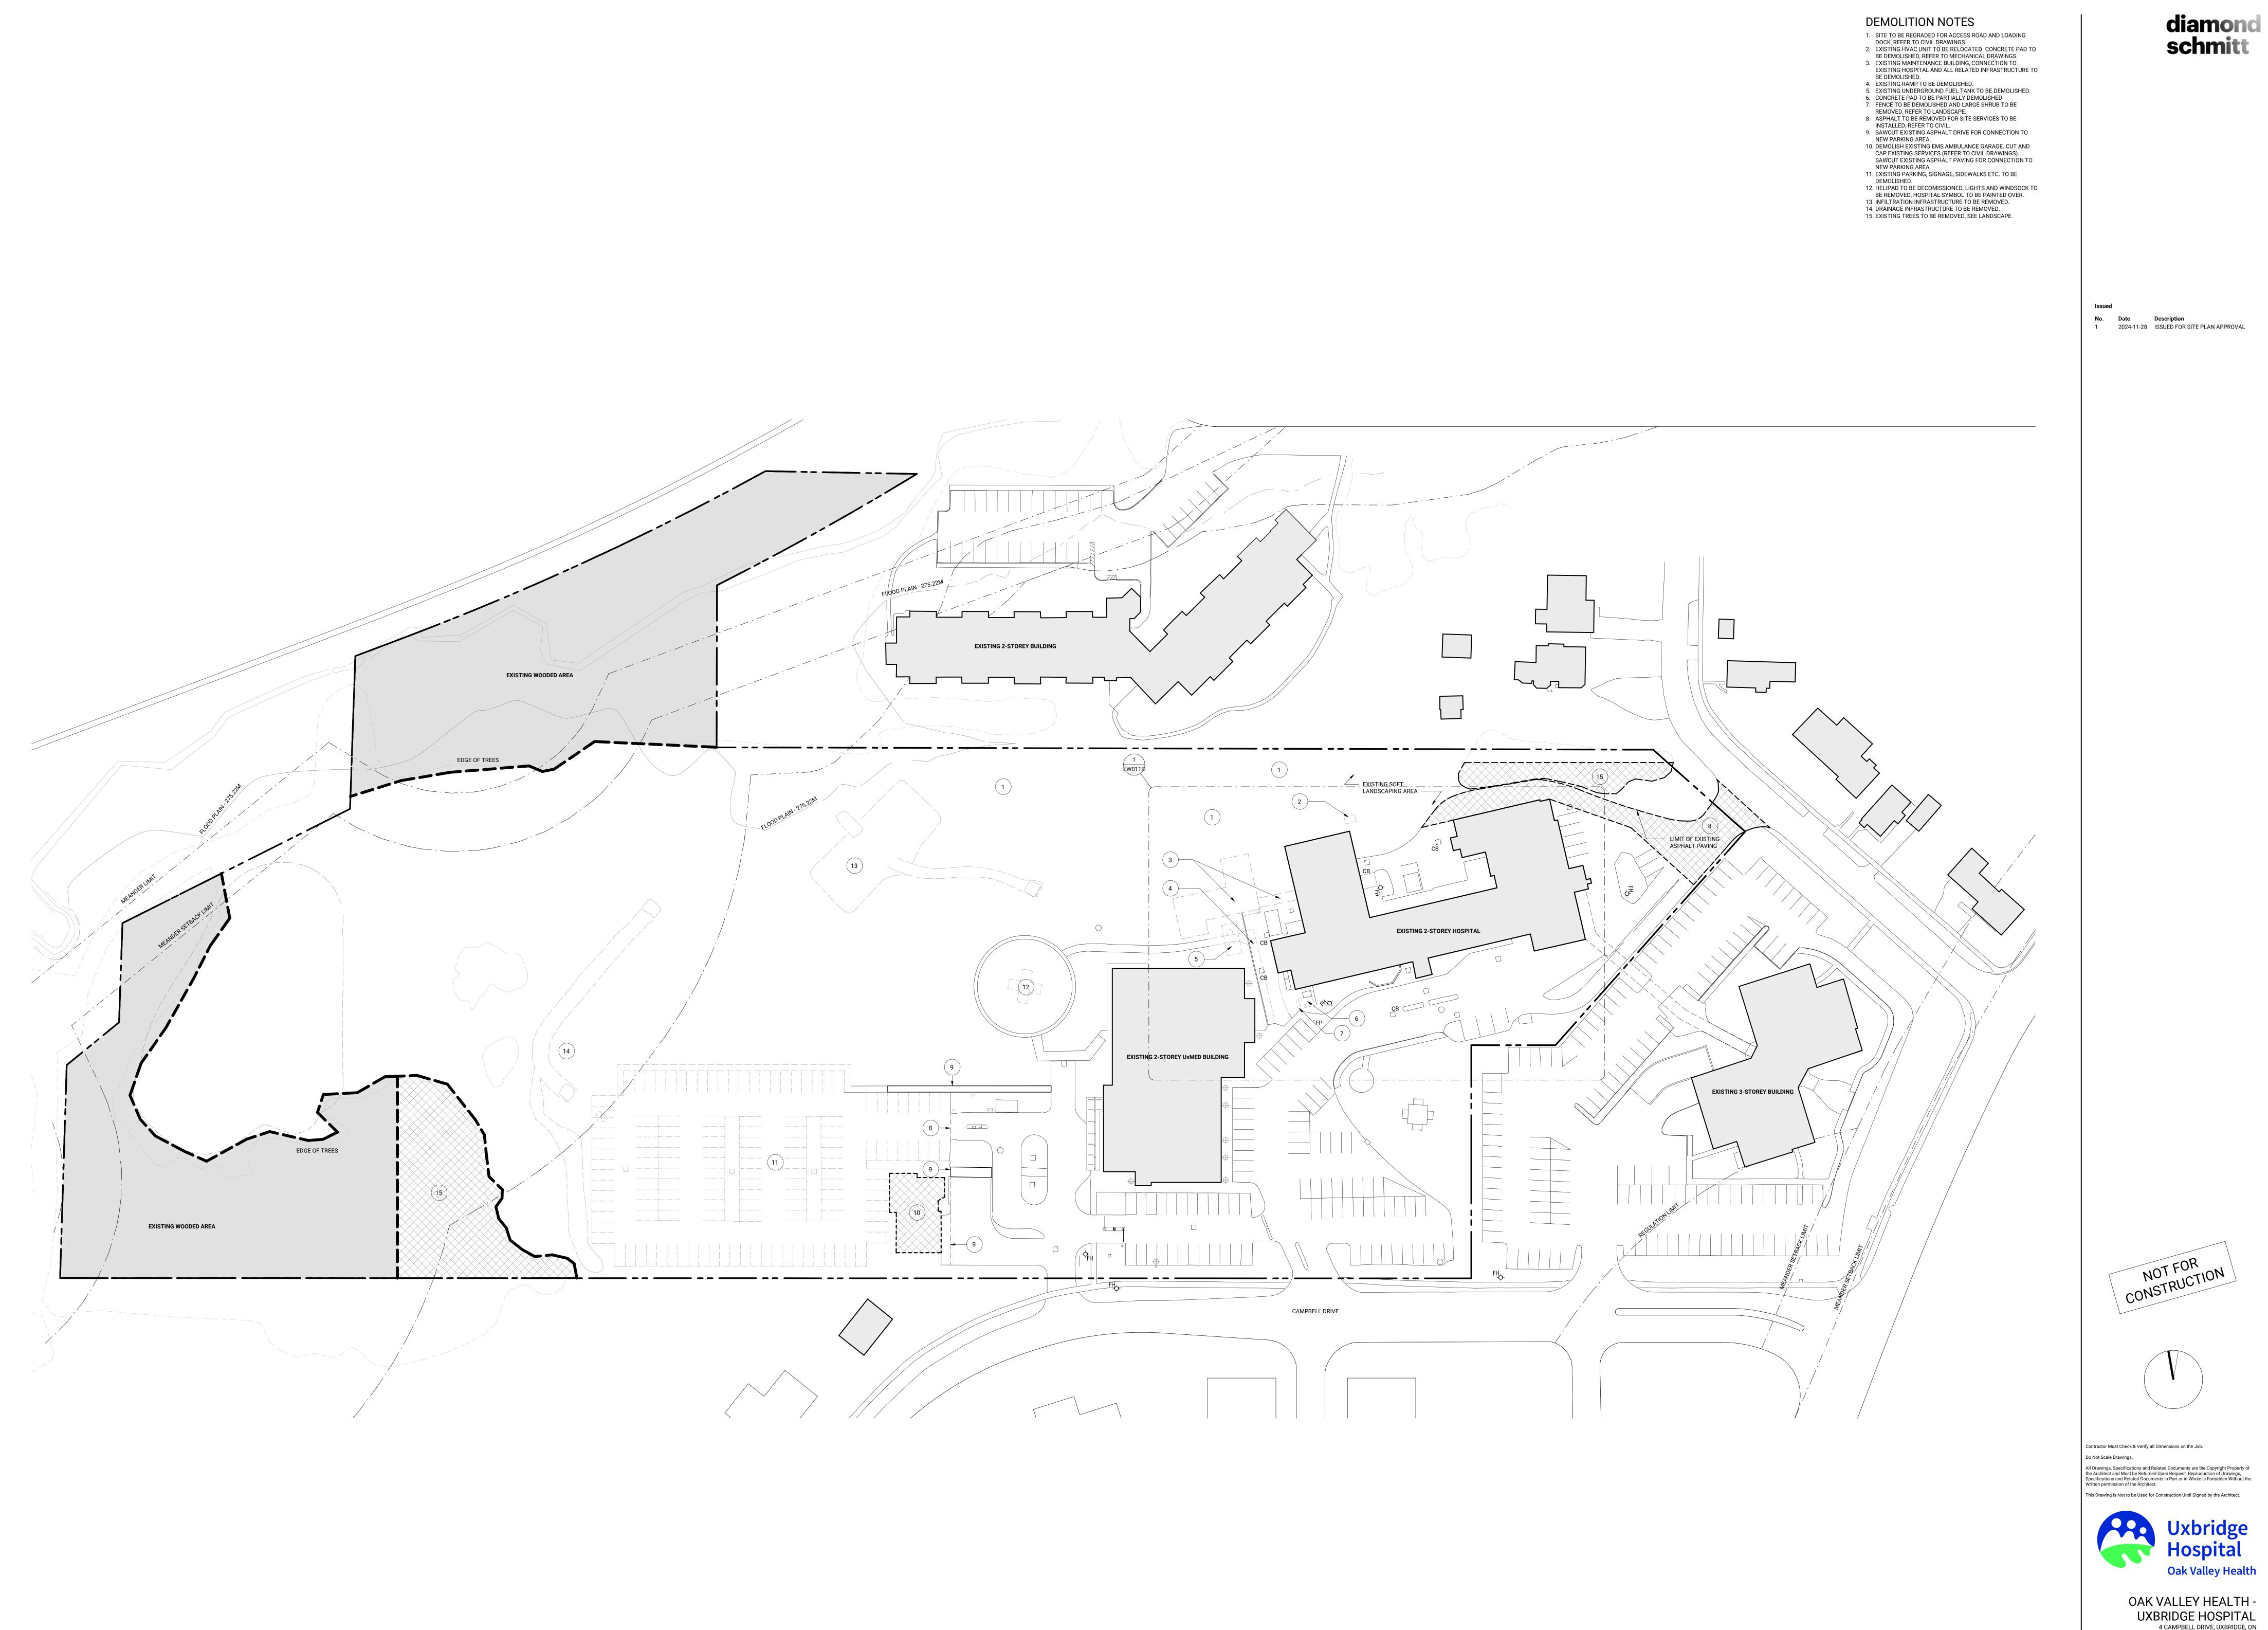



UXBRIDGE HOSPITAL 4 CAMPBELL DRIVE, UXBRIDGE, ON PROJECT NO.: 231022

EARLY WORKS - DEMOLITION SITE PLAN 1 : 500

EW011A




SITE PHOTO 11 - EXISTING HOSPITAL. SLOPE TO BE REGRADED NORTH OF THE ASPHALT FOR NEW LOCATIONS OF EXISTING HVAC UNIT



SITE PHOTO 7- EXISTING 1-STOREY ADDITION TO BE DEMOLISHED



SITE PHOTO 2 - WOOD FRAME WALKWAY AND GUARD TO BE REMOVED

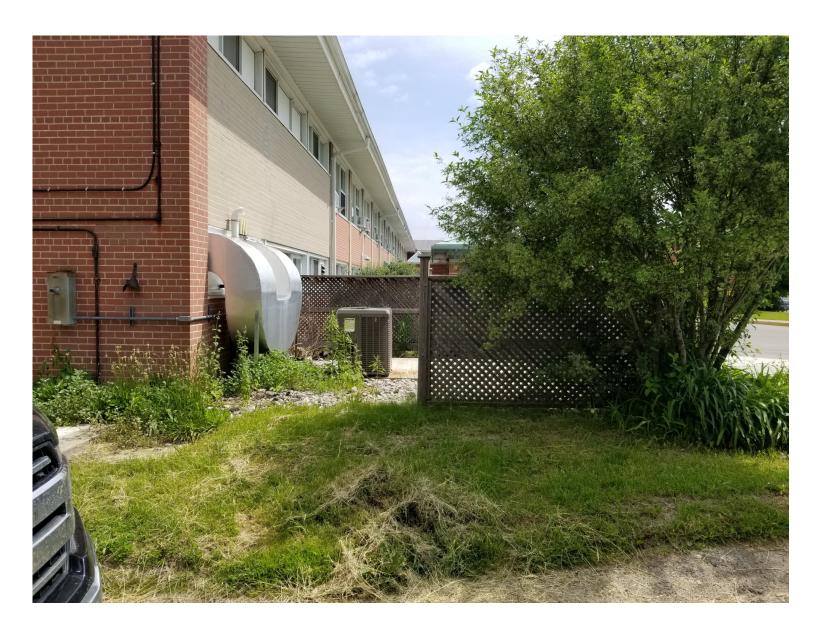


SITE PHOTO 1 - CONDENSER UNIT TO REMAIN. SHRUB AND FENCE TO **BE REMOVED**



SITE PHOTO 10 - EXISTING HVAC UNIT TO BE RELOCATED



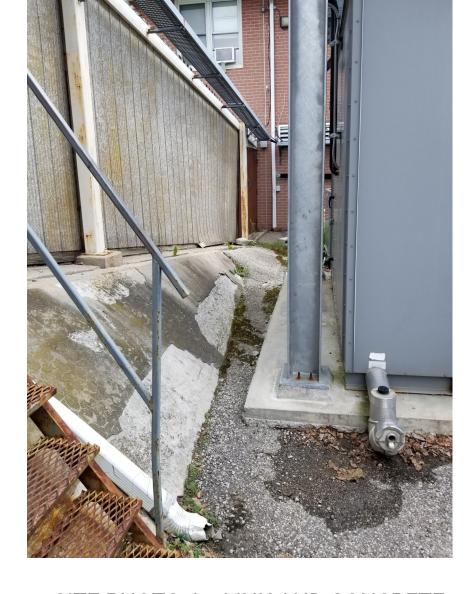

SITE PHOTO 6 - LINK AND CONCRETE BERM TO BE REMOVED. EXISTING HVAC UNIT TO REMAIN














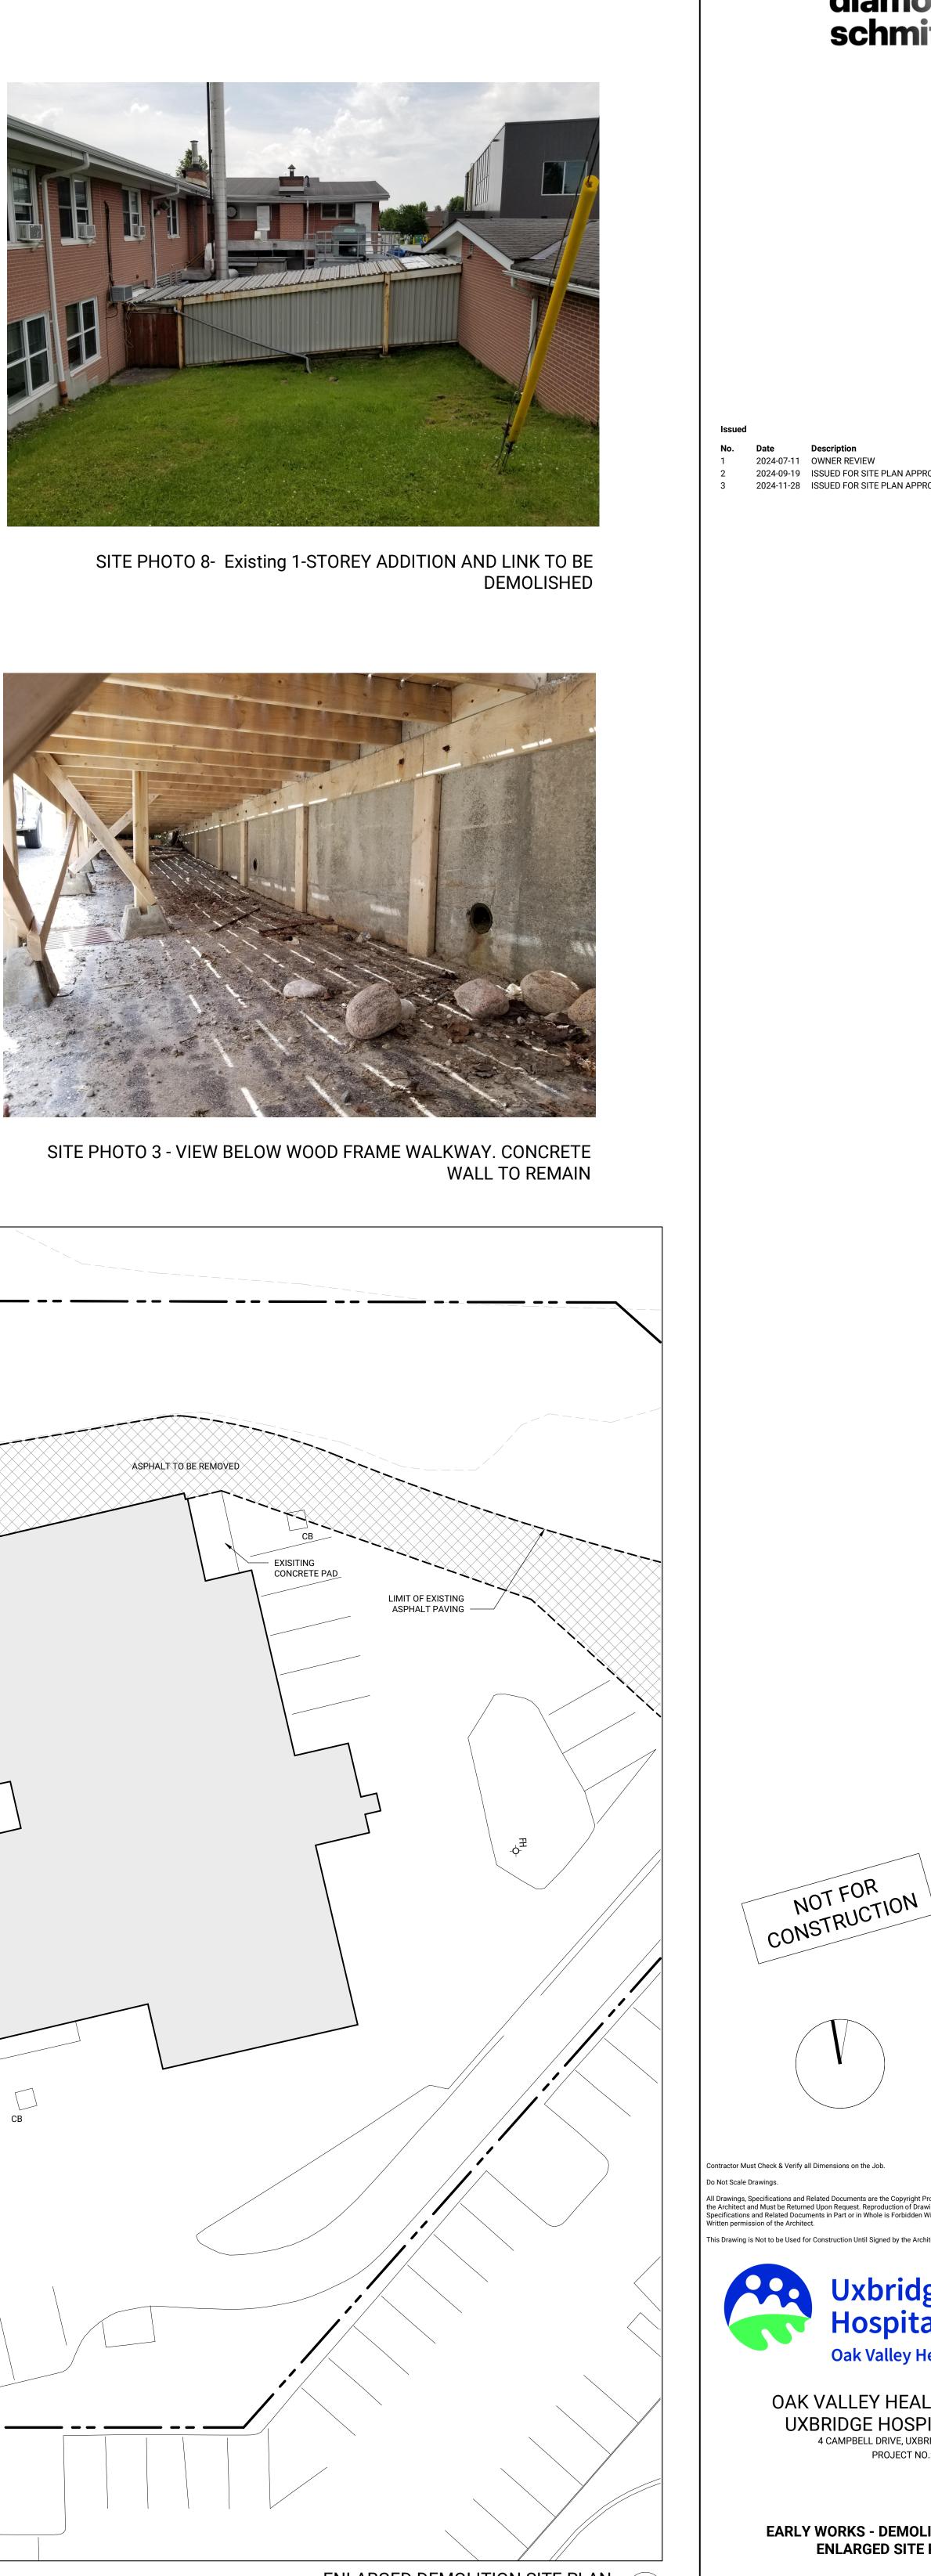

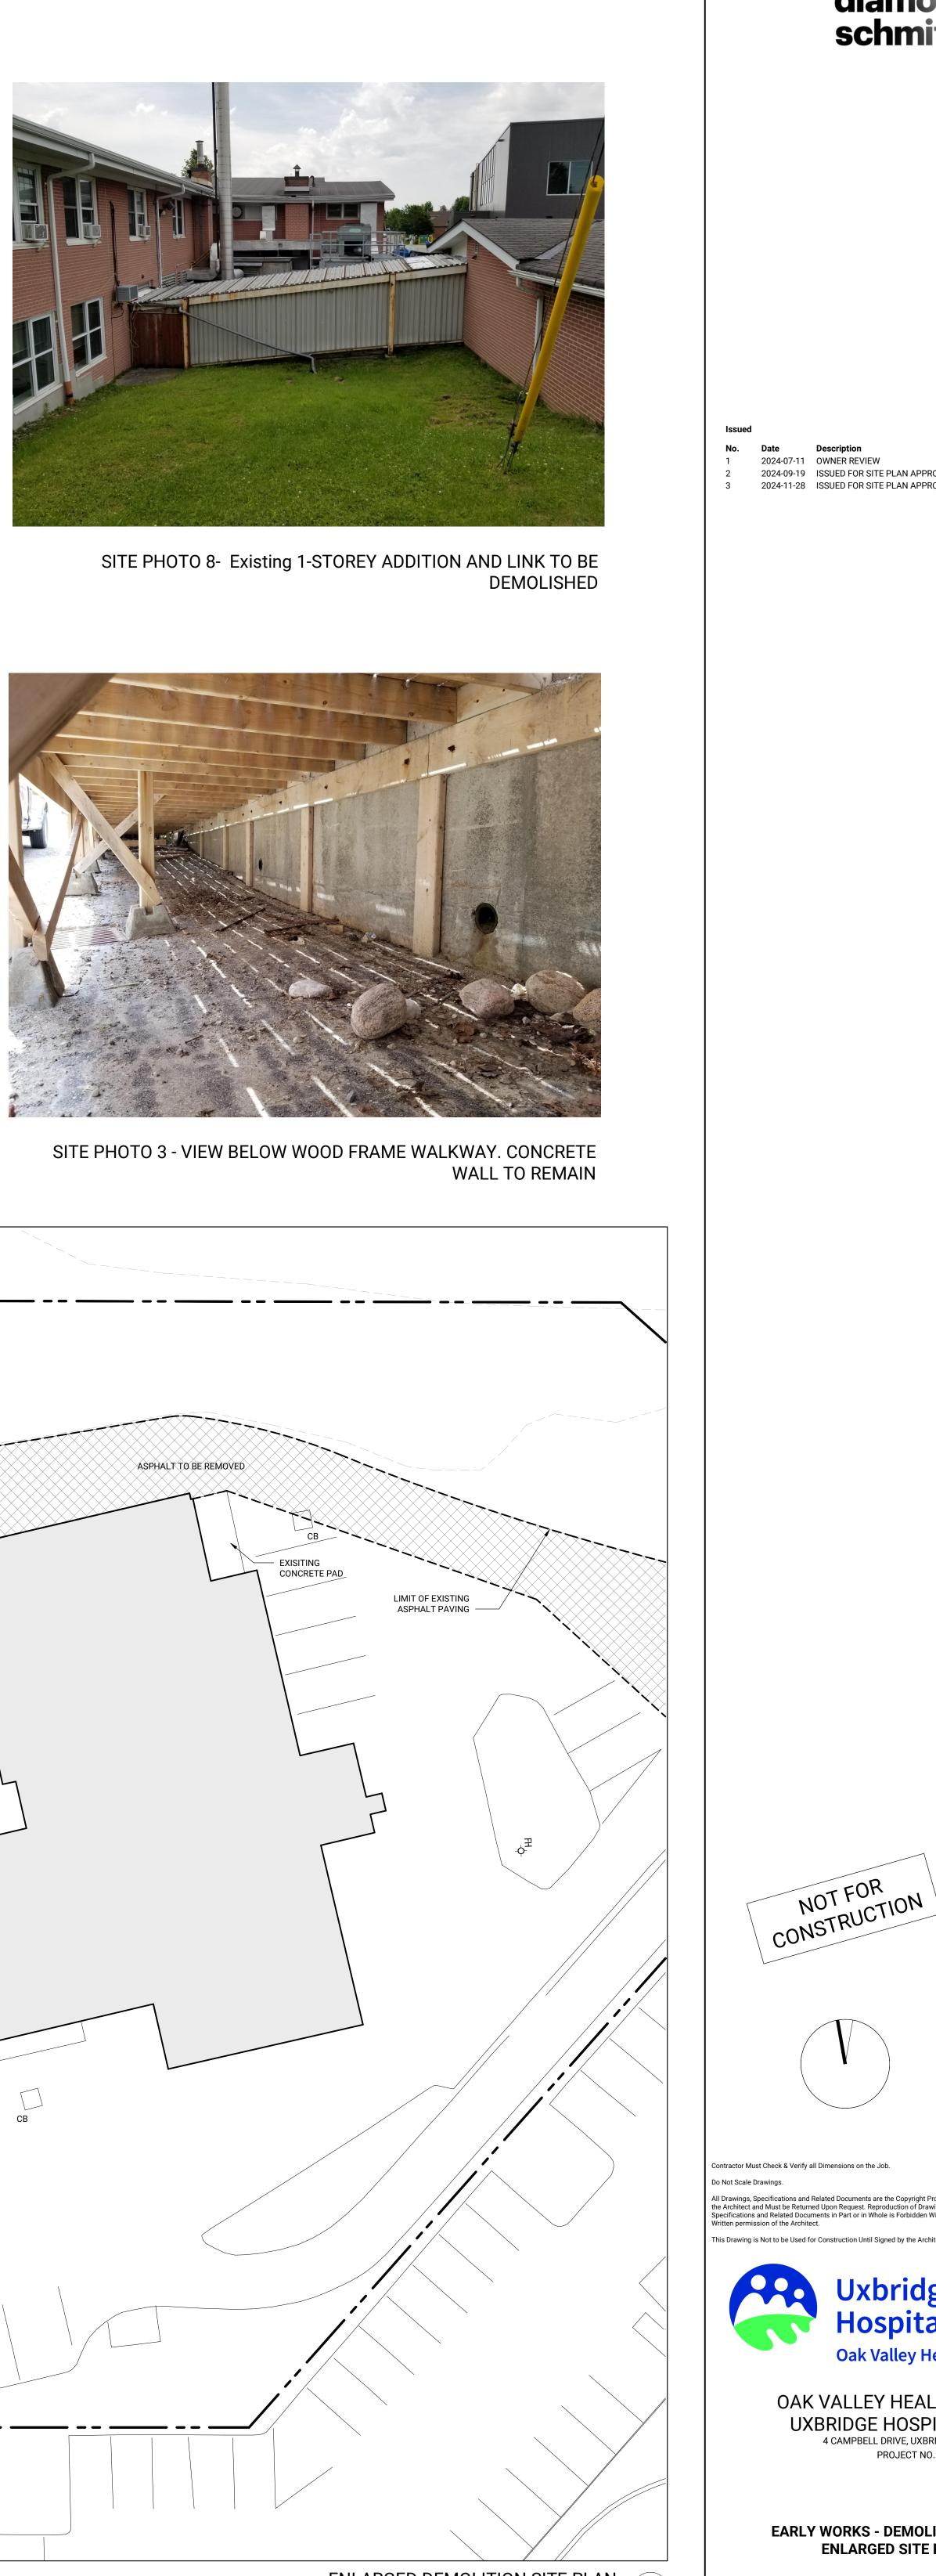


ENLARGED DEMOLITION SITE PLAN 1:200 EW011B ENLARGED SITE PLAN 1:200

EW011B

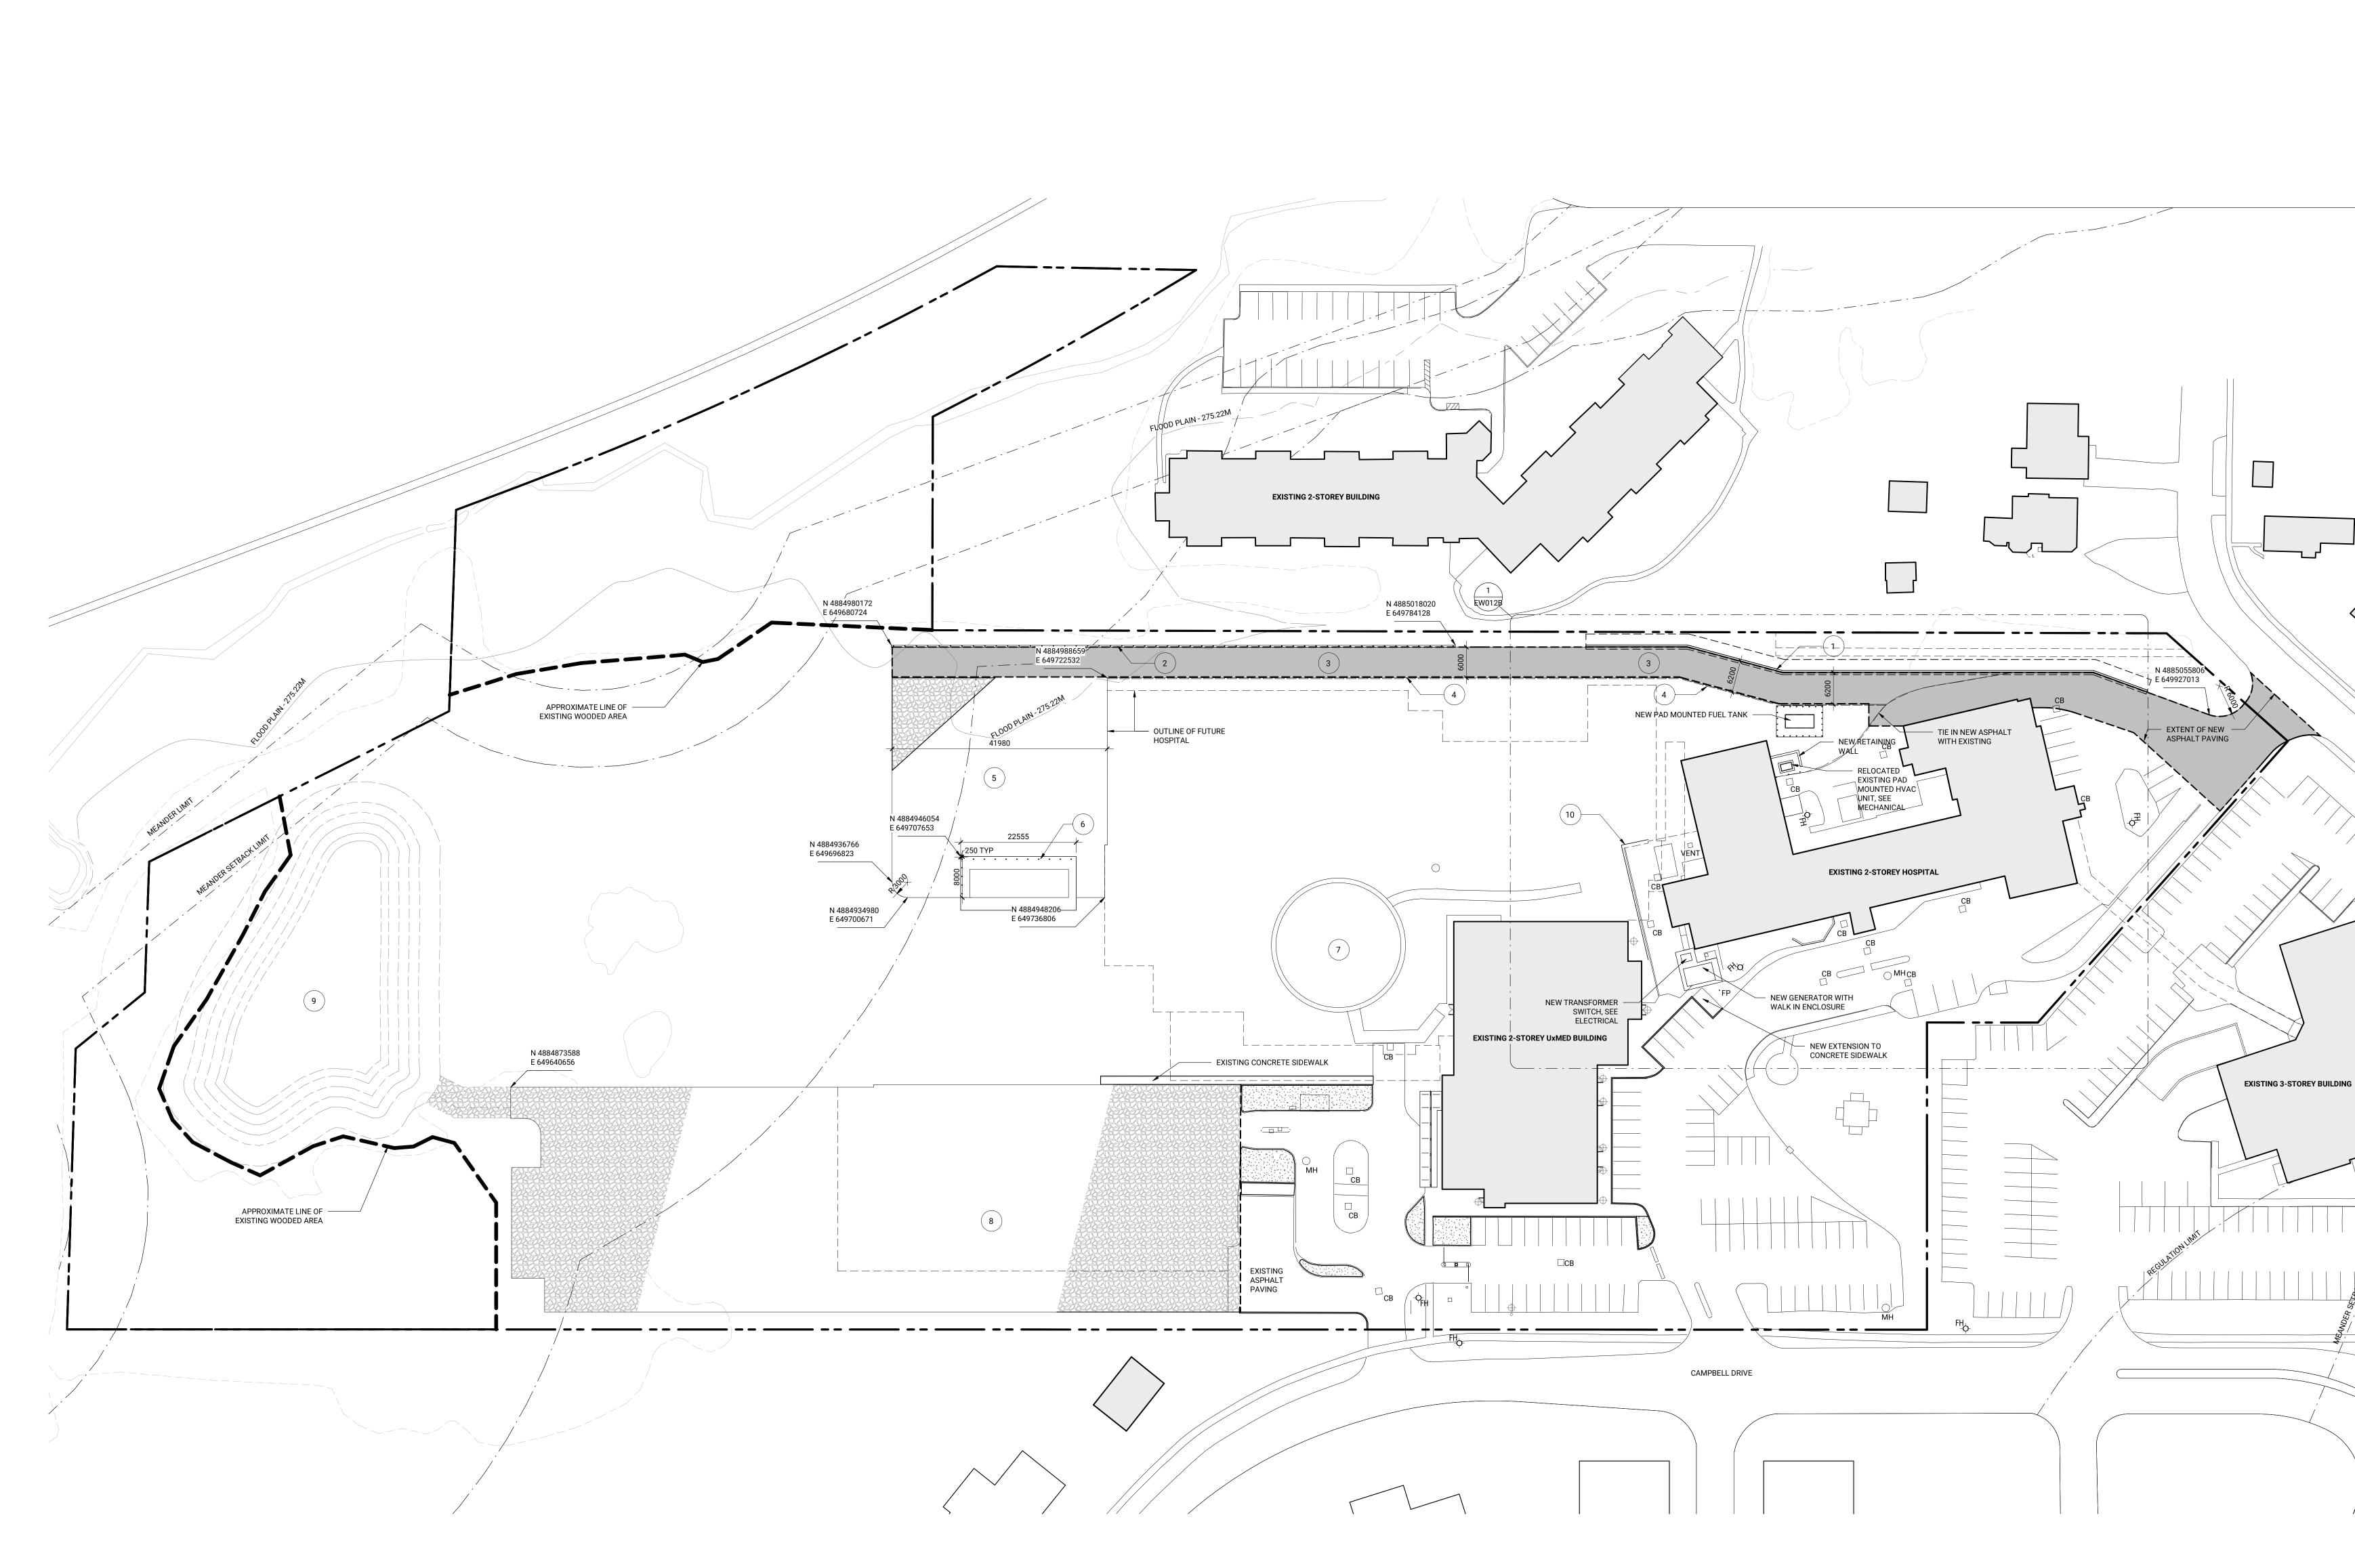



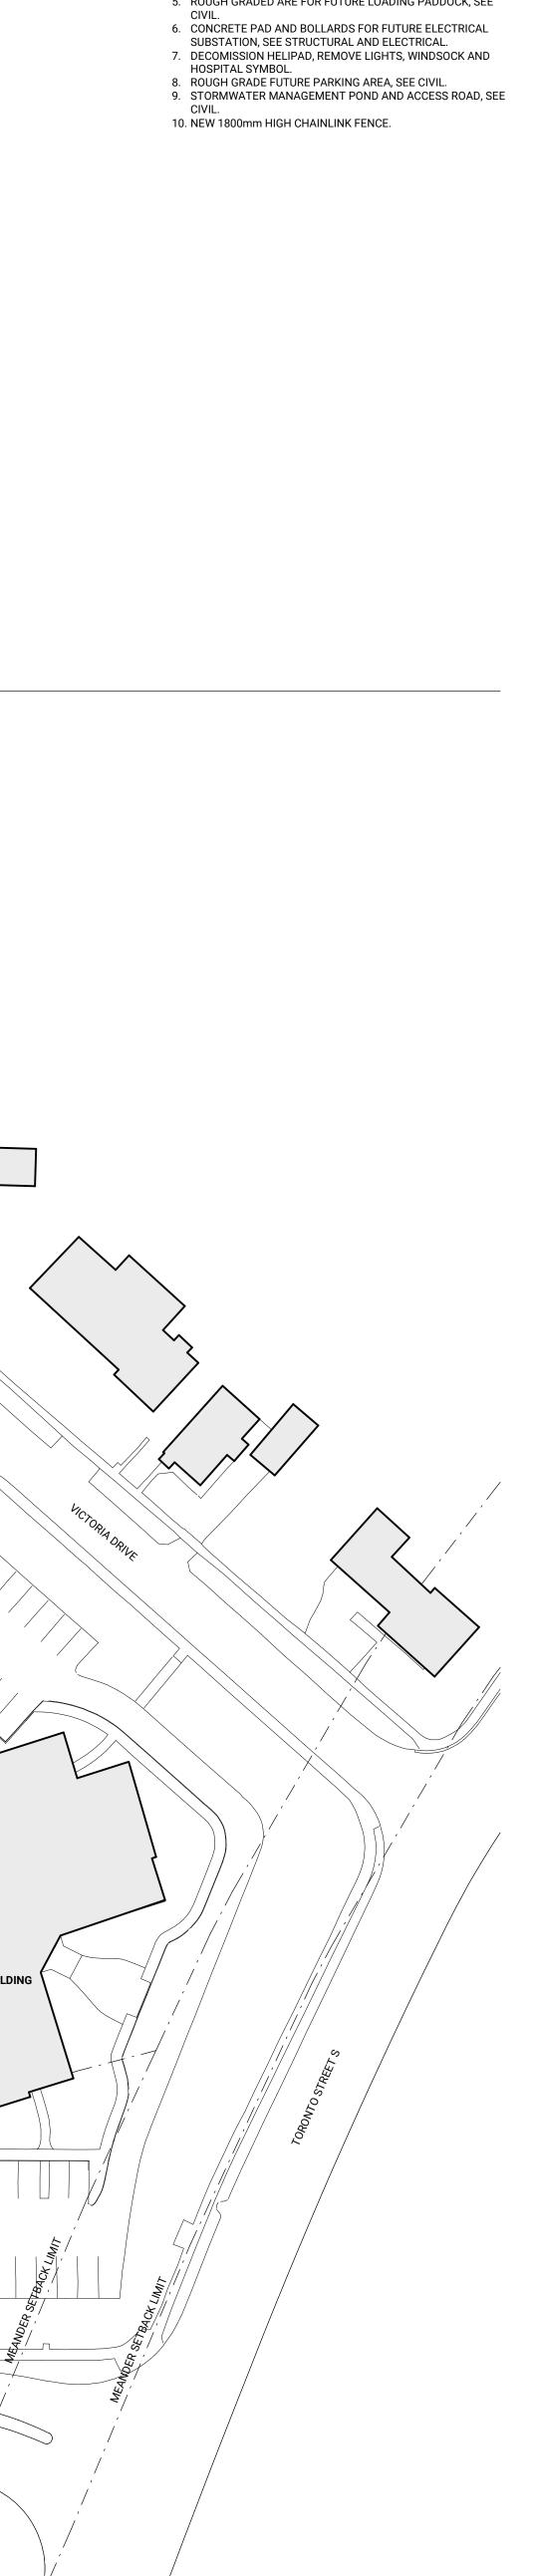

SITE NOTES

 CONCRETE RETAINING WALL, SEE STRUCTURAL.
CONCRETE RETAINING WALL WITH BOLLARDS, SEE STRUCTURAL.

ACCESS ROAD, SEE CIVIL.
PRECAST BARRIER CURBS, SEE LANDSCAPE.
ROUGH GRADED ARE FOR FUTURE LOADING PADDOCK, SEE

diamond schmitt

IssuedNo.DateDescription12024-11-28ISSUED FOR SITE PLAN APPROVAL

NOT FOR CONSTRUCTION

Contractor Must Check & Verify all Dimensions on the Job. Do Not Scale Drawings. All Drawings, Specifications and Related Documents are the Copyright Property of the Architect and Must be Returned Upon Request. Reproduction of Drawings, Specifications and Related Documents in Part or in Whole is Forbidden Without the Written permission of the Architect.

This Drawing is Not to be Used for Construction Until Signed by the Architect.





OAK VALLEY HEALTH -UXBRIDGE HOSPITAL 4 CAMPBELL DRIVE, UXBRIDGE, ON PROJECT NO.: 231022

EARLY WORKS - SITE PLAN 1 : 500



Autodesk Docs://231022-Uxbridge Hospital-R24/231022-ARCH-DSA-Building-R24

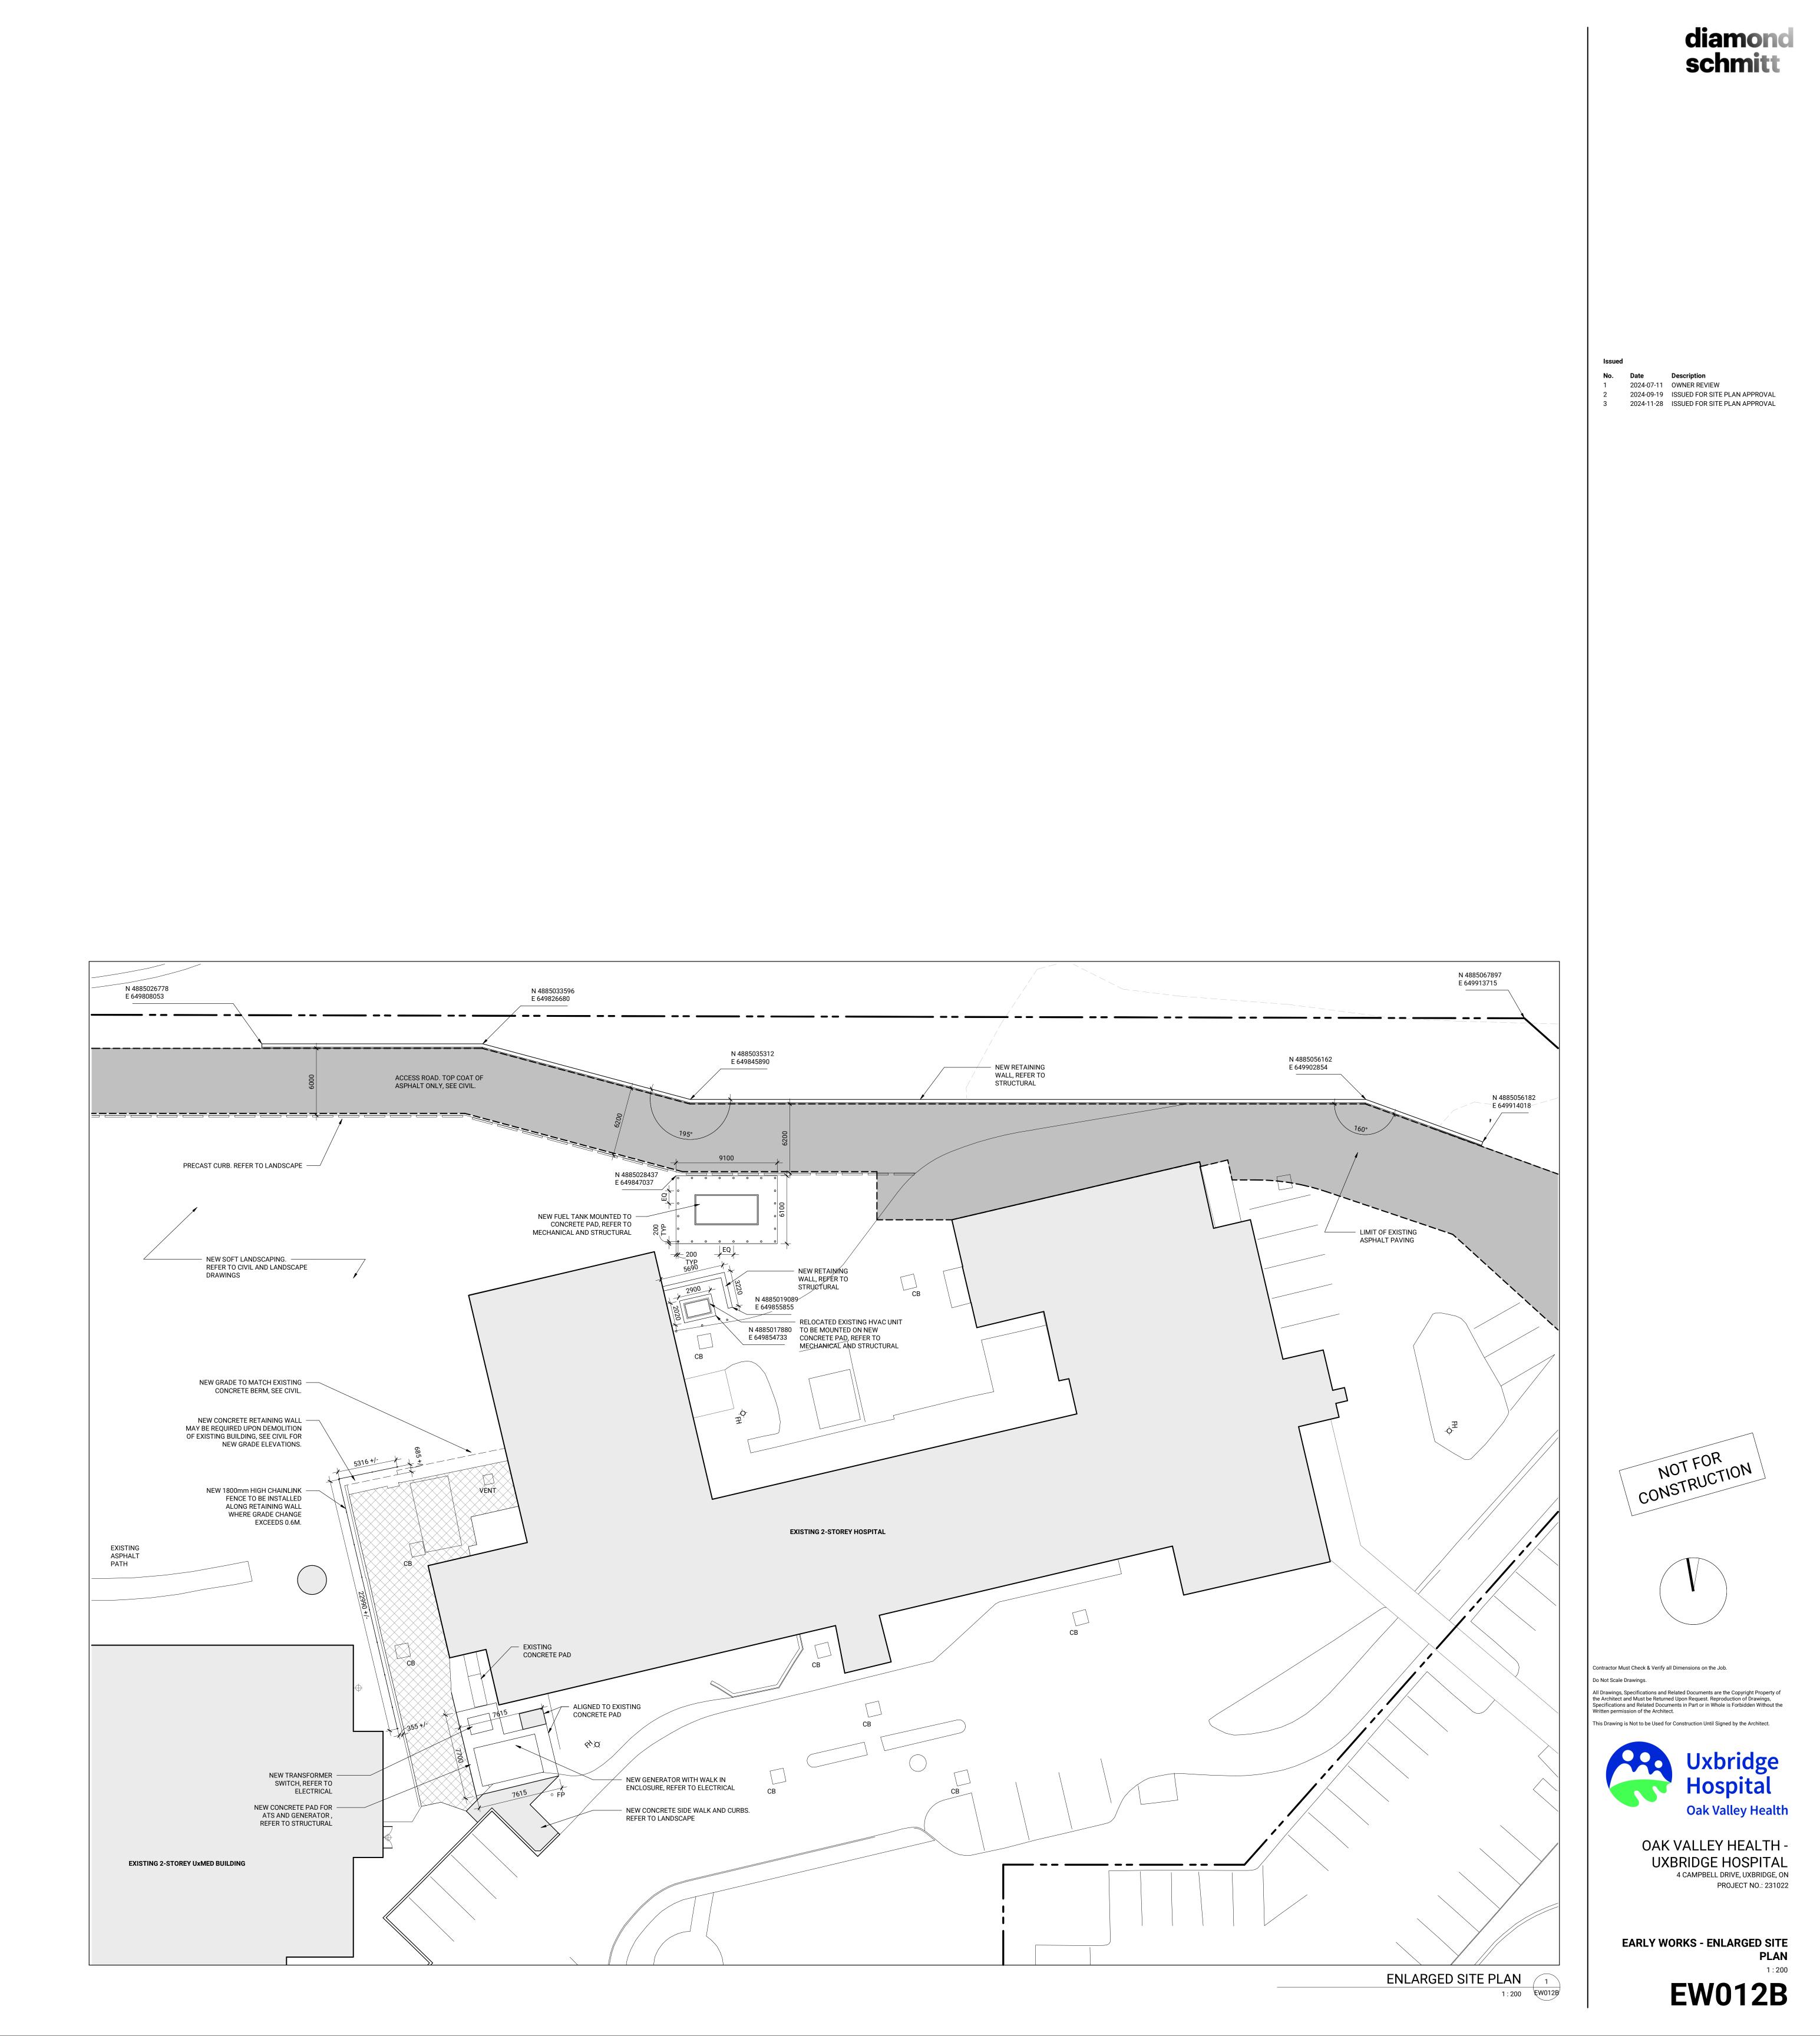

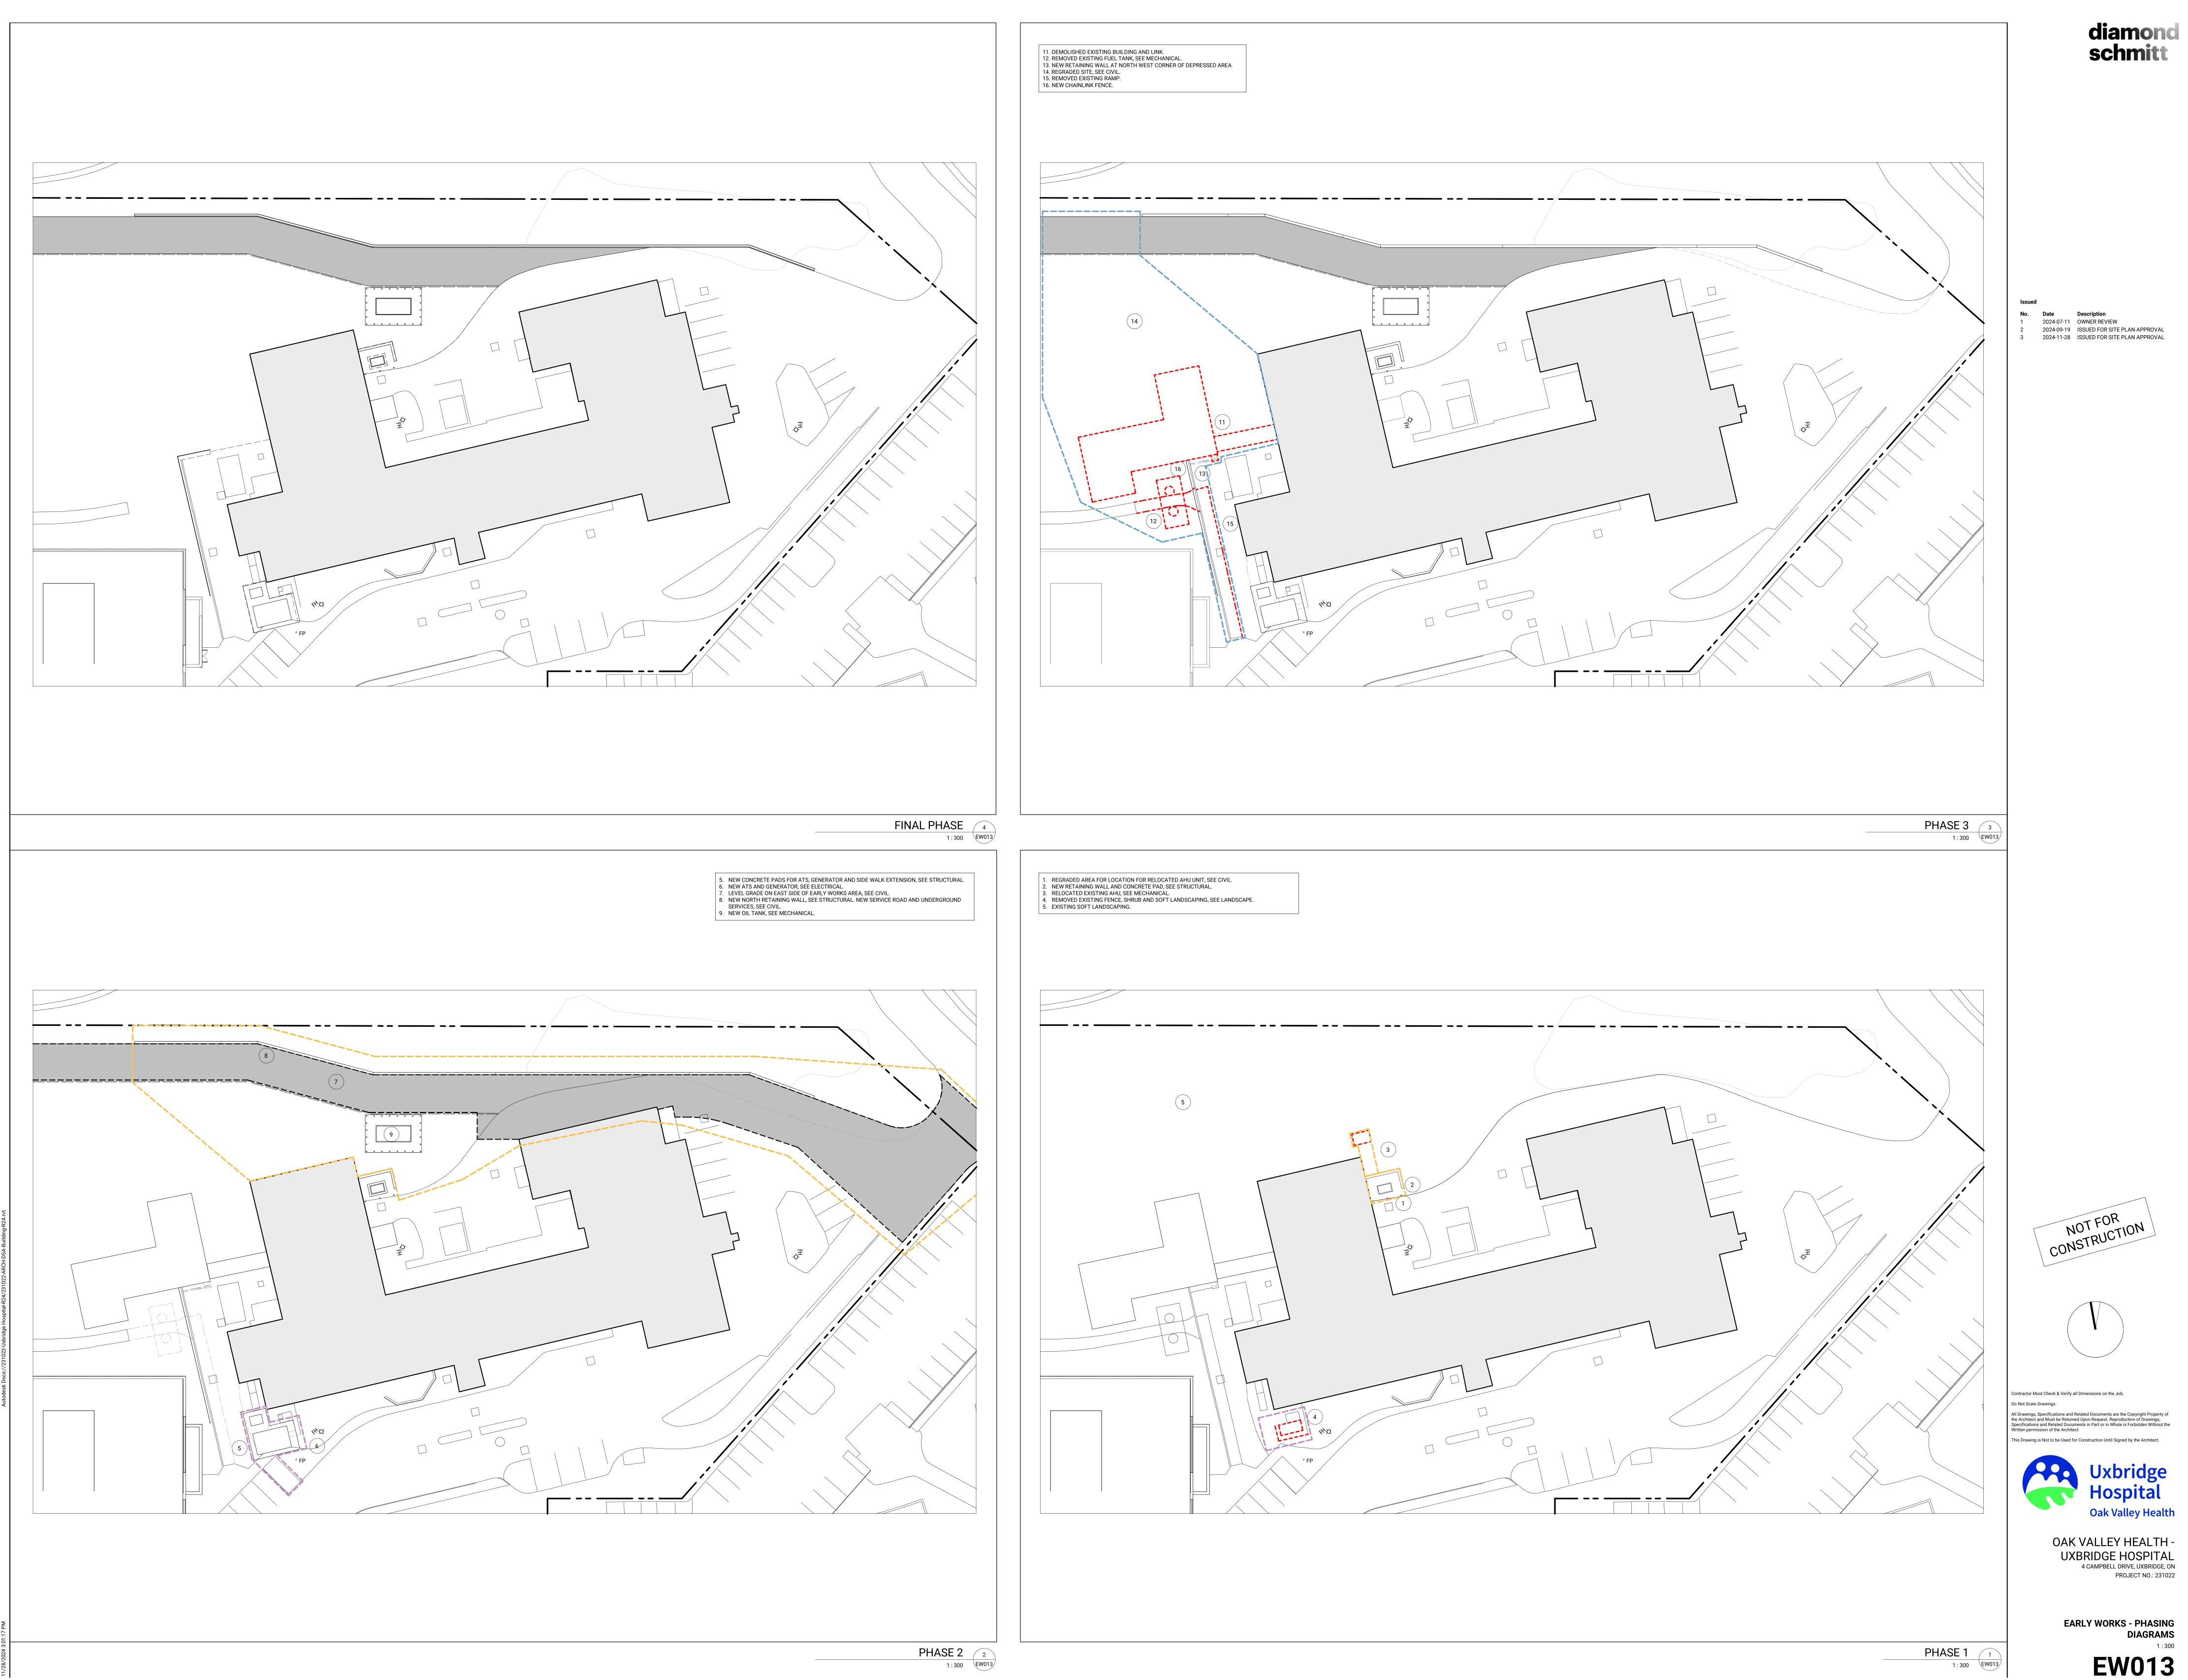

INTERIOR PARTITION TYPES P43 STC 47 OBC SB-3 S4b P43 PARTITION WITH INSULATION 965

